


VISION.06

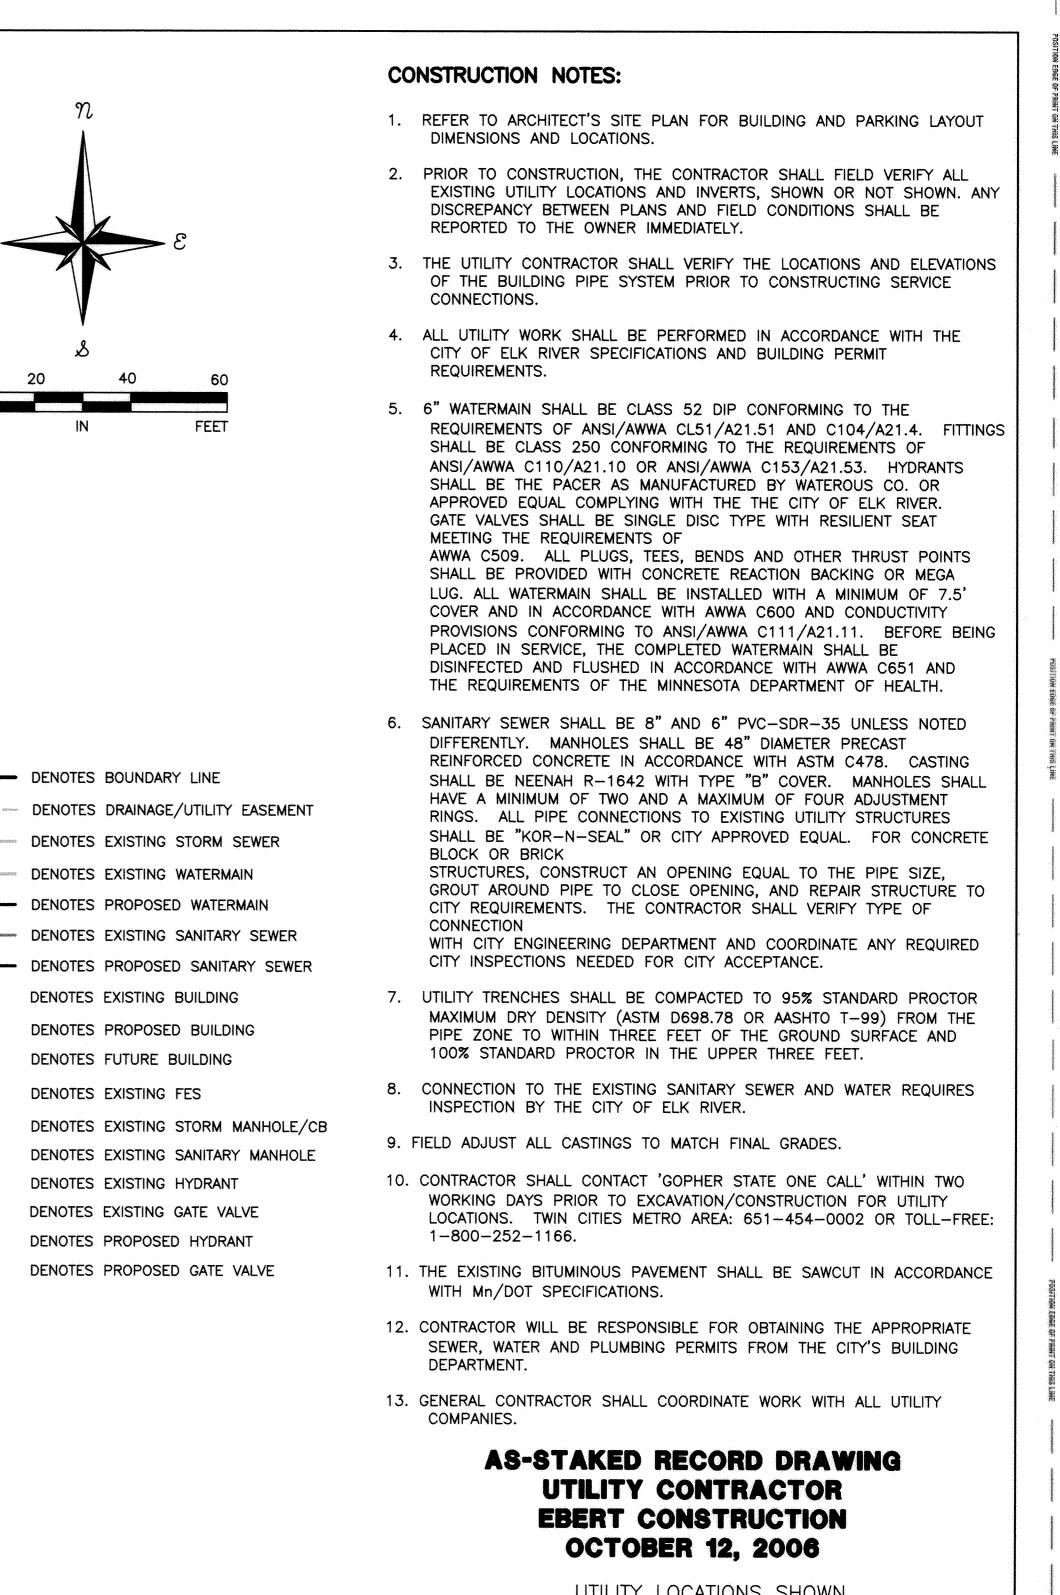

UTILITY LOCATIONS SHOWN ARE BASED ON AS-STAKED LOCATIONS FOR CONSTRUCTION. EBERT CONSTRUCTION CONFIRMED UTILITES CONSTRUCTED AS-STAKED.

SEE ELK RIDGE CENTER 3RD ADDITION FOR STORM SEWER CONSTRUCTION

AS-STAKED RECORD DRAWING

UTILITY PLAN

Date: Description: Description: 04/27/06 | City Comments ADDED CLEANOUT ON SANITARY SERVICE ZRE 10/12/06 AS-STAKED DRAWING MCH 12/4/06 AS-STAKED DRAWING REVISIONS MCH

POND

I hereby certify that this plan was prepared by me or under my direct supervision and that I am a Licensed Professional Engineer under the laws of the State of Minnesota.

___ Reg. No. ____12048

Date: 02/24/06

6.83

·8'-21" RCP @ 0.27% W/ PLUG

-WATERMAIN-

/6" GV-1-

EX CBMH105 RIM=979.75 INV=975.09S 974.99N

RIM = 979.92

INV = 969.24

EX CBNH104A

PLACE 6" DIP WATERMAIN —

WATERMAIN-

PARKING

UNDER STORM SEWER. MAINTAIN 18" SEPARATION

CONNECT TO EXISTING

6" SANITARY EX. INV=968.08

(FIELD VARIFY)

RIM=080.6

INV=974/31

PARKING

6"x6" TEE, 12.5'-6" DIP 7 6" VALVE, HYDRANT

INV=973.77

EX CBMH105

M=973/75SE 973.659

R14=979.20

BUILDING

INV=970.80

BEND

Drawn By: Checked By:



15050 23rd Avenue North Plymouth, Minnesota 55447 T 763-746-1600 F 763-746-1699 554 Third Street NW, Suite 100 Elk River, Minnesota 55330 T 763-241-0108 F 763-241-8351

www.schoellmadson.com

Client:

LEGEND

69'-24" RCP @ 0.28% /W/ PLUG

EXISTING 8" DIP W/

EX RIN = 980.97 EX NV =866.38 N

EX INV =986.37 (S)

|W| = |967.24 (W)|

8"X6" REDUCER

EBERT CONSTRUCTION

WARNING THE CONTRACTOR SHALL CONTACT ALL PUBLIC UTILITIES FOR LOCATIONS OF ALL UNDERGROUND WIRES, CABLES,

CONDUITS, PIPES, MANHOLES, VALVES, OR OTHER BURIED STRUCTURES BEFORE DIGGING. HE SHALL REPAIR OR

> REPLACE THE ABOVE WHEN DAMAGED DURING CONSTRUCTION AT NO COST TO OWNER.

> > 23350 COUNTY ROAD 10 CORCORAN, MN 55357 (763) 498-7844

Sheet Title:

Project Name/Location PEARLE VISION ELK RIDGE CENTER ELK RIVER, MN

02/23/06

Date:

SMI Project Number: 80040-00

